



DANE COUNTY DEPARTMENT of PUBLIC WORKS, HIGHWAY and TRANSPORTATION

County Executive
Joseph T. Parisi

1919 Alliant Energy Center Way ♦ Madison, Wisconsin 53713
Phone: (608) 266-4018 ♦ Fax: (608) 267-1533

Commissioner / Director
Gerald J. Mandli

December 5, 2014

ATTENTION ALL REQUEST FOR BID (RFB) HOLDERS

RFB NO. 314037 - ADDENDUM NO. 1

BLUE SHED GAS DETECTION AND VENTILATION

HIGHWAY STORAGE FACILITY

BIDS DUE: THURSDAY, DECEMBER 11, 2014, 2:00 PM. DUE DATE AND TIME ARE NOT CHANGED BY THIS ADDENDUM.

This Addendum is issued to modify, explain or clarify the original Request for Bid (RFB) and is hereby made a part of the RFB. Please attach this Addendum to the RFB.

PLEASE MAKE THE FOLLOWING CHANGES:

1. Section 23 09 26

Page 1 – Line 43, add the following:

“The manufacturer’s representative shall employ service technicians located within 100 miles of the project site and provide after hours emergency service.”

2. Section 23 09 93

Page 3 – Line 41, add the following:

“For each fan EF-6 and EF-7 provide a manually activated 1 hour countdown timer to start the fan on manual activation and shut the fan off when the timer reaches the countdown time. If the fan is also activated by the gas detection system when the timer times out the fan shall remain in operation.”

Page 4 – Line 39, add the following:

“For fan EF-9 provide a manually activated 1 hour countdown timer to start the fan on manual activation and shut the fan off when the timer reaches the countdown time. If the fan is also activated by the gas detection system when the timer times out the fan shall remain in operation.”

3. Sheet E100

Modify current Sheet E100 by adding the following:

- a) WP GFCI duplex receptacle (Ckt 21), on the exterior of the building at the north wall below EF-9 for maintenance of this fan (Alternate Bid only).
- b) Duplex receptacle (Ckt 21) mounted 42” AFF on the interior of the building at the north wall for general convenience (Alternate Bid only).
- c) Ckt 21 to exterior duplex receptacle near EF-8.

Addendum No. 1

RFB No. 314037

- 1 -

rev. 08/14

- d) Plan Note #10 to read: “REMOVE EXISTING DISCONNECT SWITCH, METER, CONDUIT, HANGERS, WIRE, LOAD CENTER, AND RECEPTACLE ASSOCIATED WITH THE ABANDONED REMEDIATION EQUIPMENT. REFER TO SHEET E101 FOR CONTINUATION.”
- e) Plan Note #11 to read: “ANY CONDUIT WHICH IS FOAMED-IN AND SCHEDULED FOR REMOVAL SHALL REMAIN IN PLACE AND BE CUT OFF FLUSH WITH THE EXISTING INSULATION. CONDUIT SHALL BE FILLED WITH EXPANDING FOAM TO A MINIMUM OF 8” BACK FROM THE CUT END OF CONDUIT.”
- f) Plan Note #12 to read: “ALL NEW EXTERIOR RECEPTACLES SHALL BE MOUNTED 36” AFG.”
- g) Plan Note #11 to EF-6 and EF-7.

Revise drawing – Refer to attached supplemental sheet “SD1”.

4. Sheet E101

Revise drawing – Refer to attached supplemental sheet “SD2”.

5. Sheet M100

Modify current Sheet M100 by revising the following:

- a) Locate manual timer/switch for EF-6 and EF-7 adjacent to the south pedestrian door located in the east wall. A separate timer shall be provided for each of the two fans.
- b) Change EF-8 (Alternate Bid fan, 3400 CFM) to EF-9.
- c) Located manual timer/switch for EF-9 adjacent to the pedestrian door located in the west wall. This is included as part of the alternate bid for EF-9 installation.

Modify current Sheet M100, Detail D by adding the following:

“ALTERNATE DESIGNS, SUGGESTED BY THE CONTRACTOR, FOR THE MUA PROTECTIVE STRUCTURE OVER THE UNIT WILL BE CONSIDERED BY THE OWNER AND ENGINEER CONSISTENT WITH PROVIDING THE SAME OR IMPROVED UNIT PROTECTION.”

6. Sheet M101

Modify current Sheet M101, Detail [A] as follows:

 

- a) Add the following to the fan schedule notes: “8. EF-9 AND ASSOCIATED DUCTWORK, DETECTION, CONTROL, AND ASSOCIATED ELECTRICAL WORK SHALL BE PROVED AS AN ALTERNATE BID.”
- b) At Mark EF-9 remarks add Note #8.

If any additional information about this Addendum is needed, please call Eric Urtes at 608/266-4798, Urtes.Eric@countyofdane.com.

Sincerely,
Eric Urtes
Project Manager


Enclosures:

Sheets SD1 and SD2

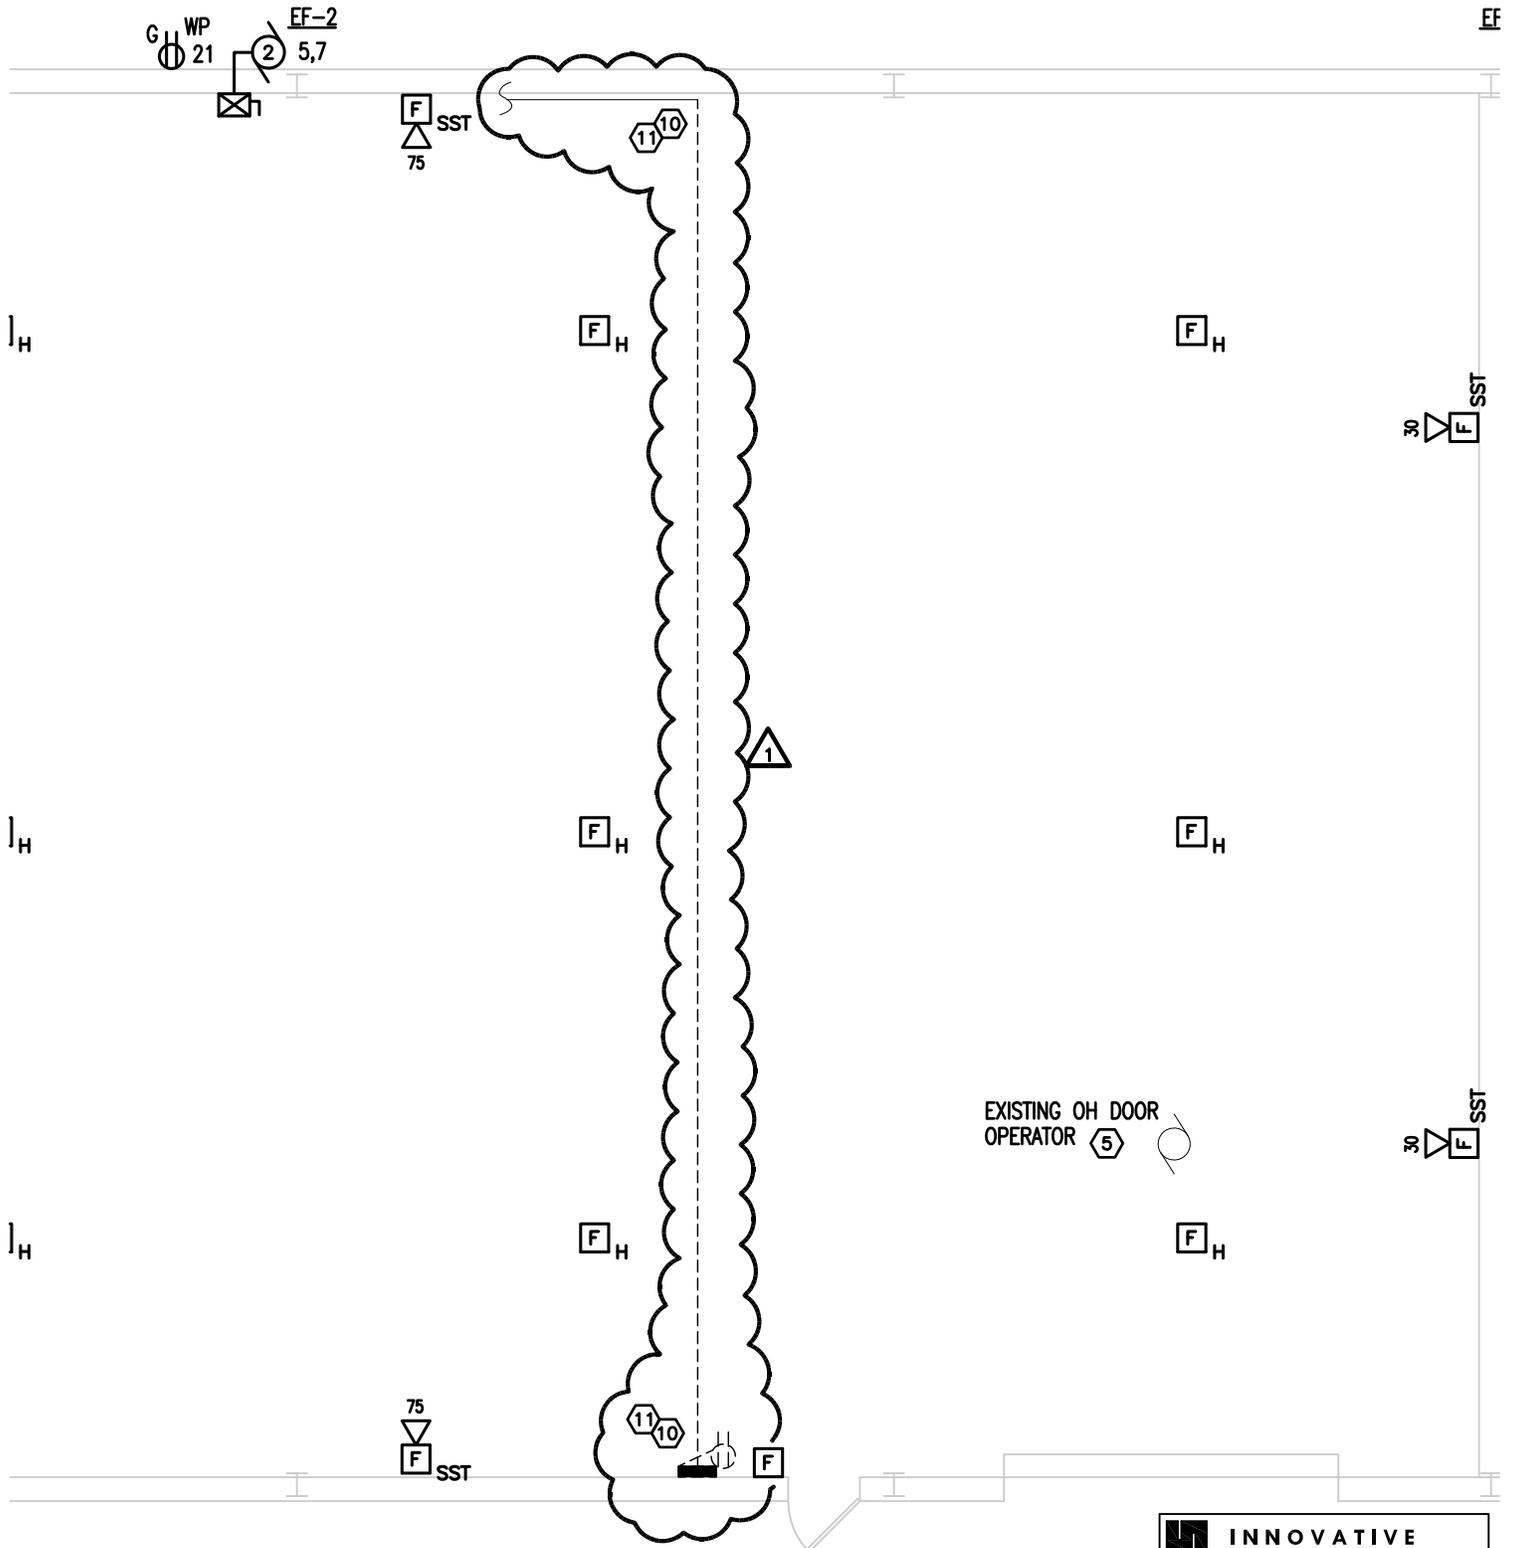

9514 Union Valley Road
 Black Earth, Wisconsin 53515
 Phone: 608-279-1717
 Email: dhill.ies@tds.net

	Project Title: BLUE SHED GAS DETECTION AND VENTILATION HIGHWAY STORAGE FACILITY 2302 FISH HATCHERY ROAD, MADISON	Scale 1/8" = 1'-0"
		Sheet Ref E100
Agency / Institution: DANE COUNTY PUBLIC WORKS, HIGHWAY & TRANSPORTATION DEPT.	Sheet Title: FIRST FLOOR PLAN - ELECTRICAL	RFB Number 314037
		Set Type ADDENDUM #1
		Date Issued 12/05/2014
		Sheet Number SD1

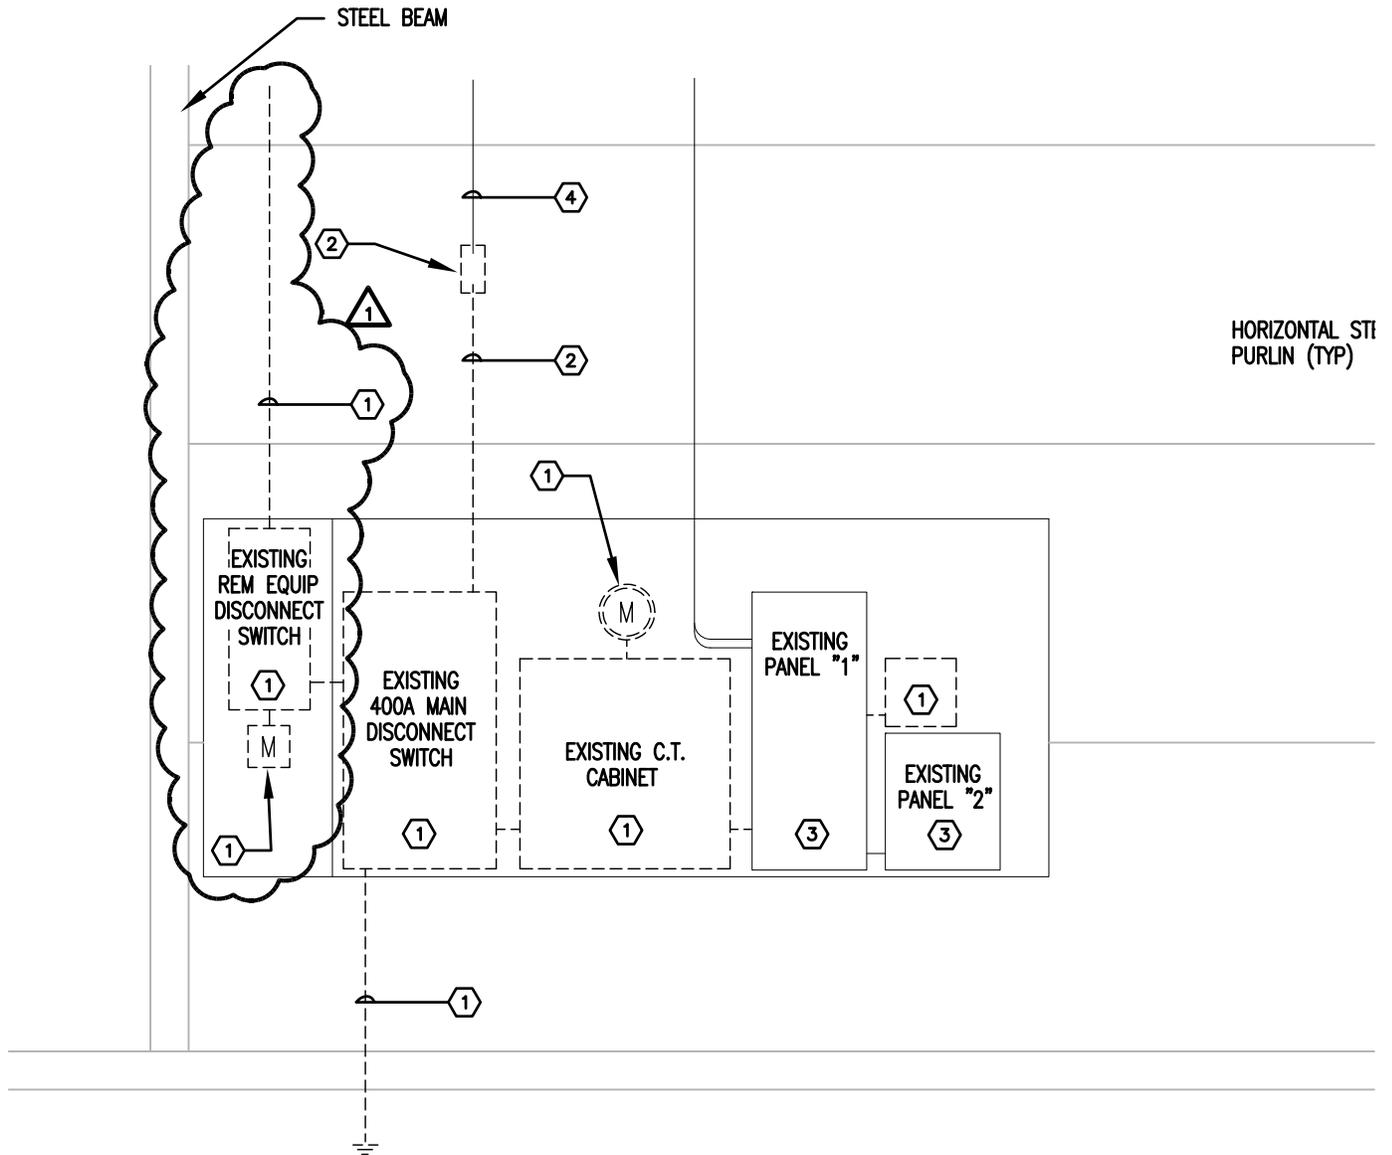

A
E101

POWER RISER DIAGRAM – DEMOLITION

NO SCALE

120/240V, 1 ϕ , 3W



9514 Union Valley Road
Black Earth, Wisconsin 53515
Phone: 608-279-1717
Email: dhill.ies@tds.net

Agency / Institution: DANE COUNTY PUBLIC WORKS, HIGHWAY & TRANSPORTATION DEPT.	Project Title: BLUE SHED GAS DETECTION AND VENTILATION	Scale	NO SCALE
	HIGHWAY STORAGE FACILITY 2302 FISH HATCHERY ROAD, MADISON	Sheet Ref	E101
	Sheet Title: SCHEDULES AND DETAILS – ELECTRICAL	RFB Number	314037
		Set Type	ADDENDUM #1
		Date Issued	12/05/2014
		Sheet Number	SD2